




1 SPRAYPAD SECTION
3/8"=1'

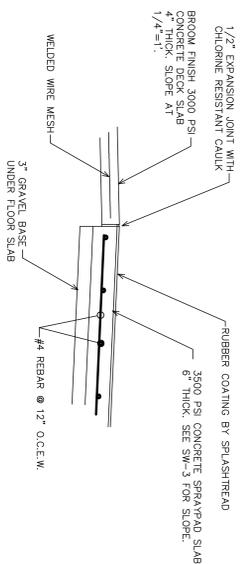


4 FLOOR SLAB SECTION
3/4"=1'

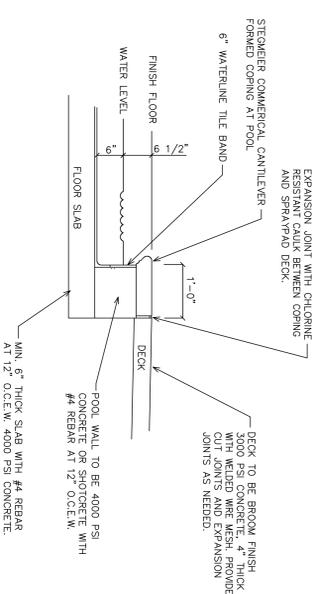



5 POOL WALL SECTION
3/4"=1'

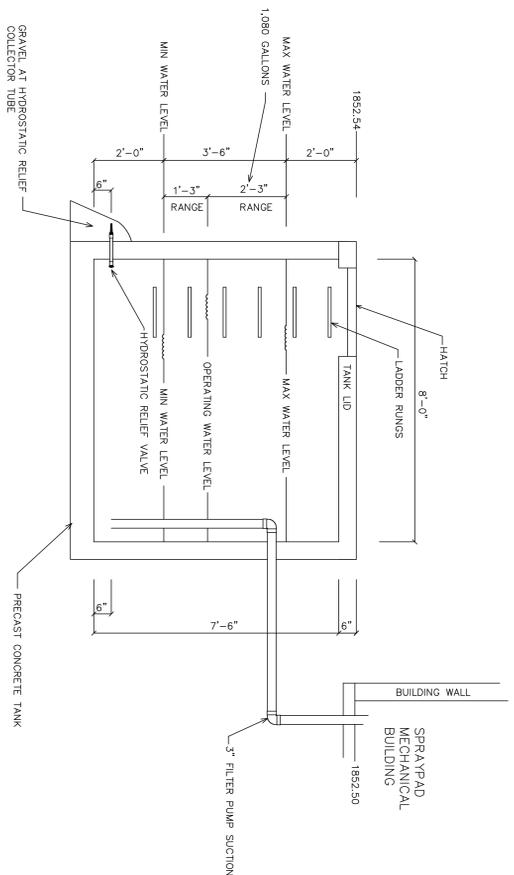


3 PUMP RESERVOIR DETAIL
1/2"=1'

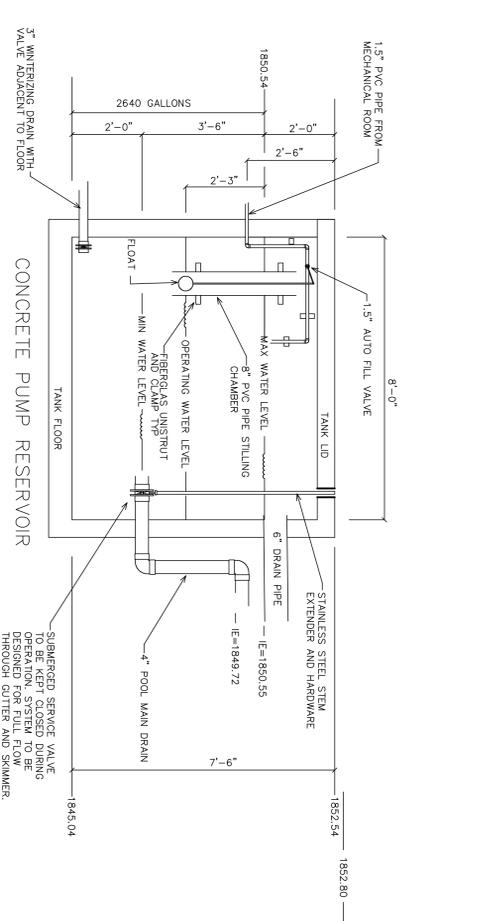

2 PUMP RESERVOIR DETAIL
1/2"=1'

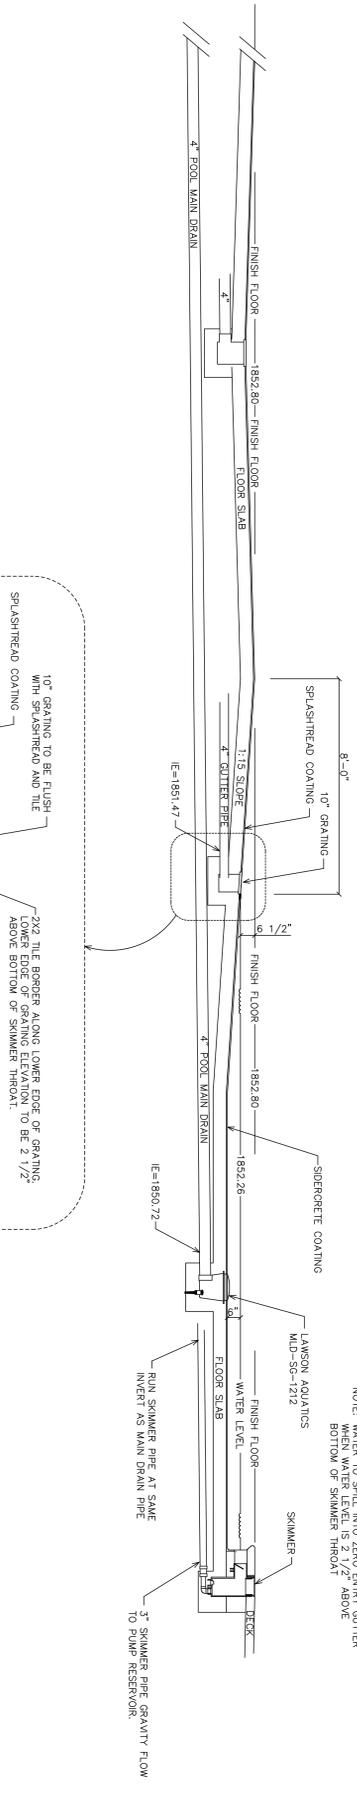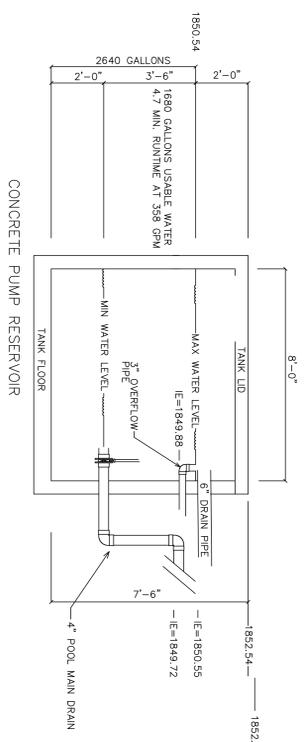

6 SPRAYPAD ELEVATIONS
3/8"=1'

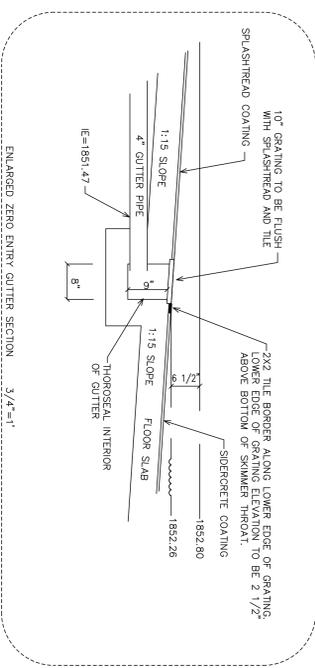

PROJECT: MEEKS PARK, UNION COUNTY
 SPRAYPAD
 11 POOL LANE
 BLAIRSVILLE, GA

WaterDesign
 997 MANSELL ROAD, SUITE B
 ROSWELL, GA. 30076

DRAWN BY: MDP
 DATE: 5/28/15
 SCALE: AS NOTED
 FOR CONSTRUCTION
 SHEET
 SPRAYPAD
 SECTIONS/DETAILS
SM-4

REVISIONS